


建筑	给排水
暖通	电气
结构	弱电
其他	其他

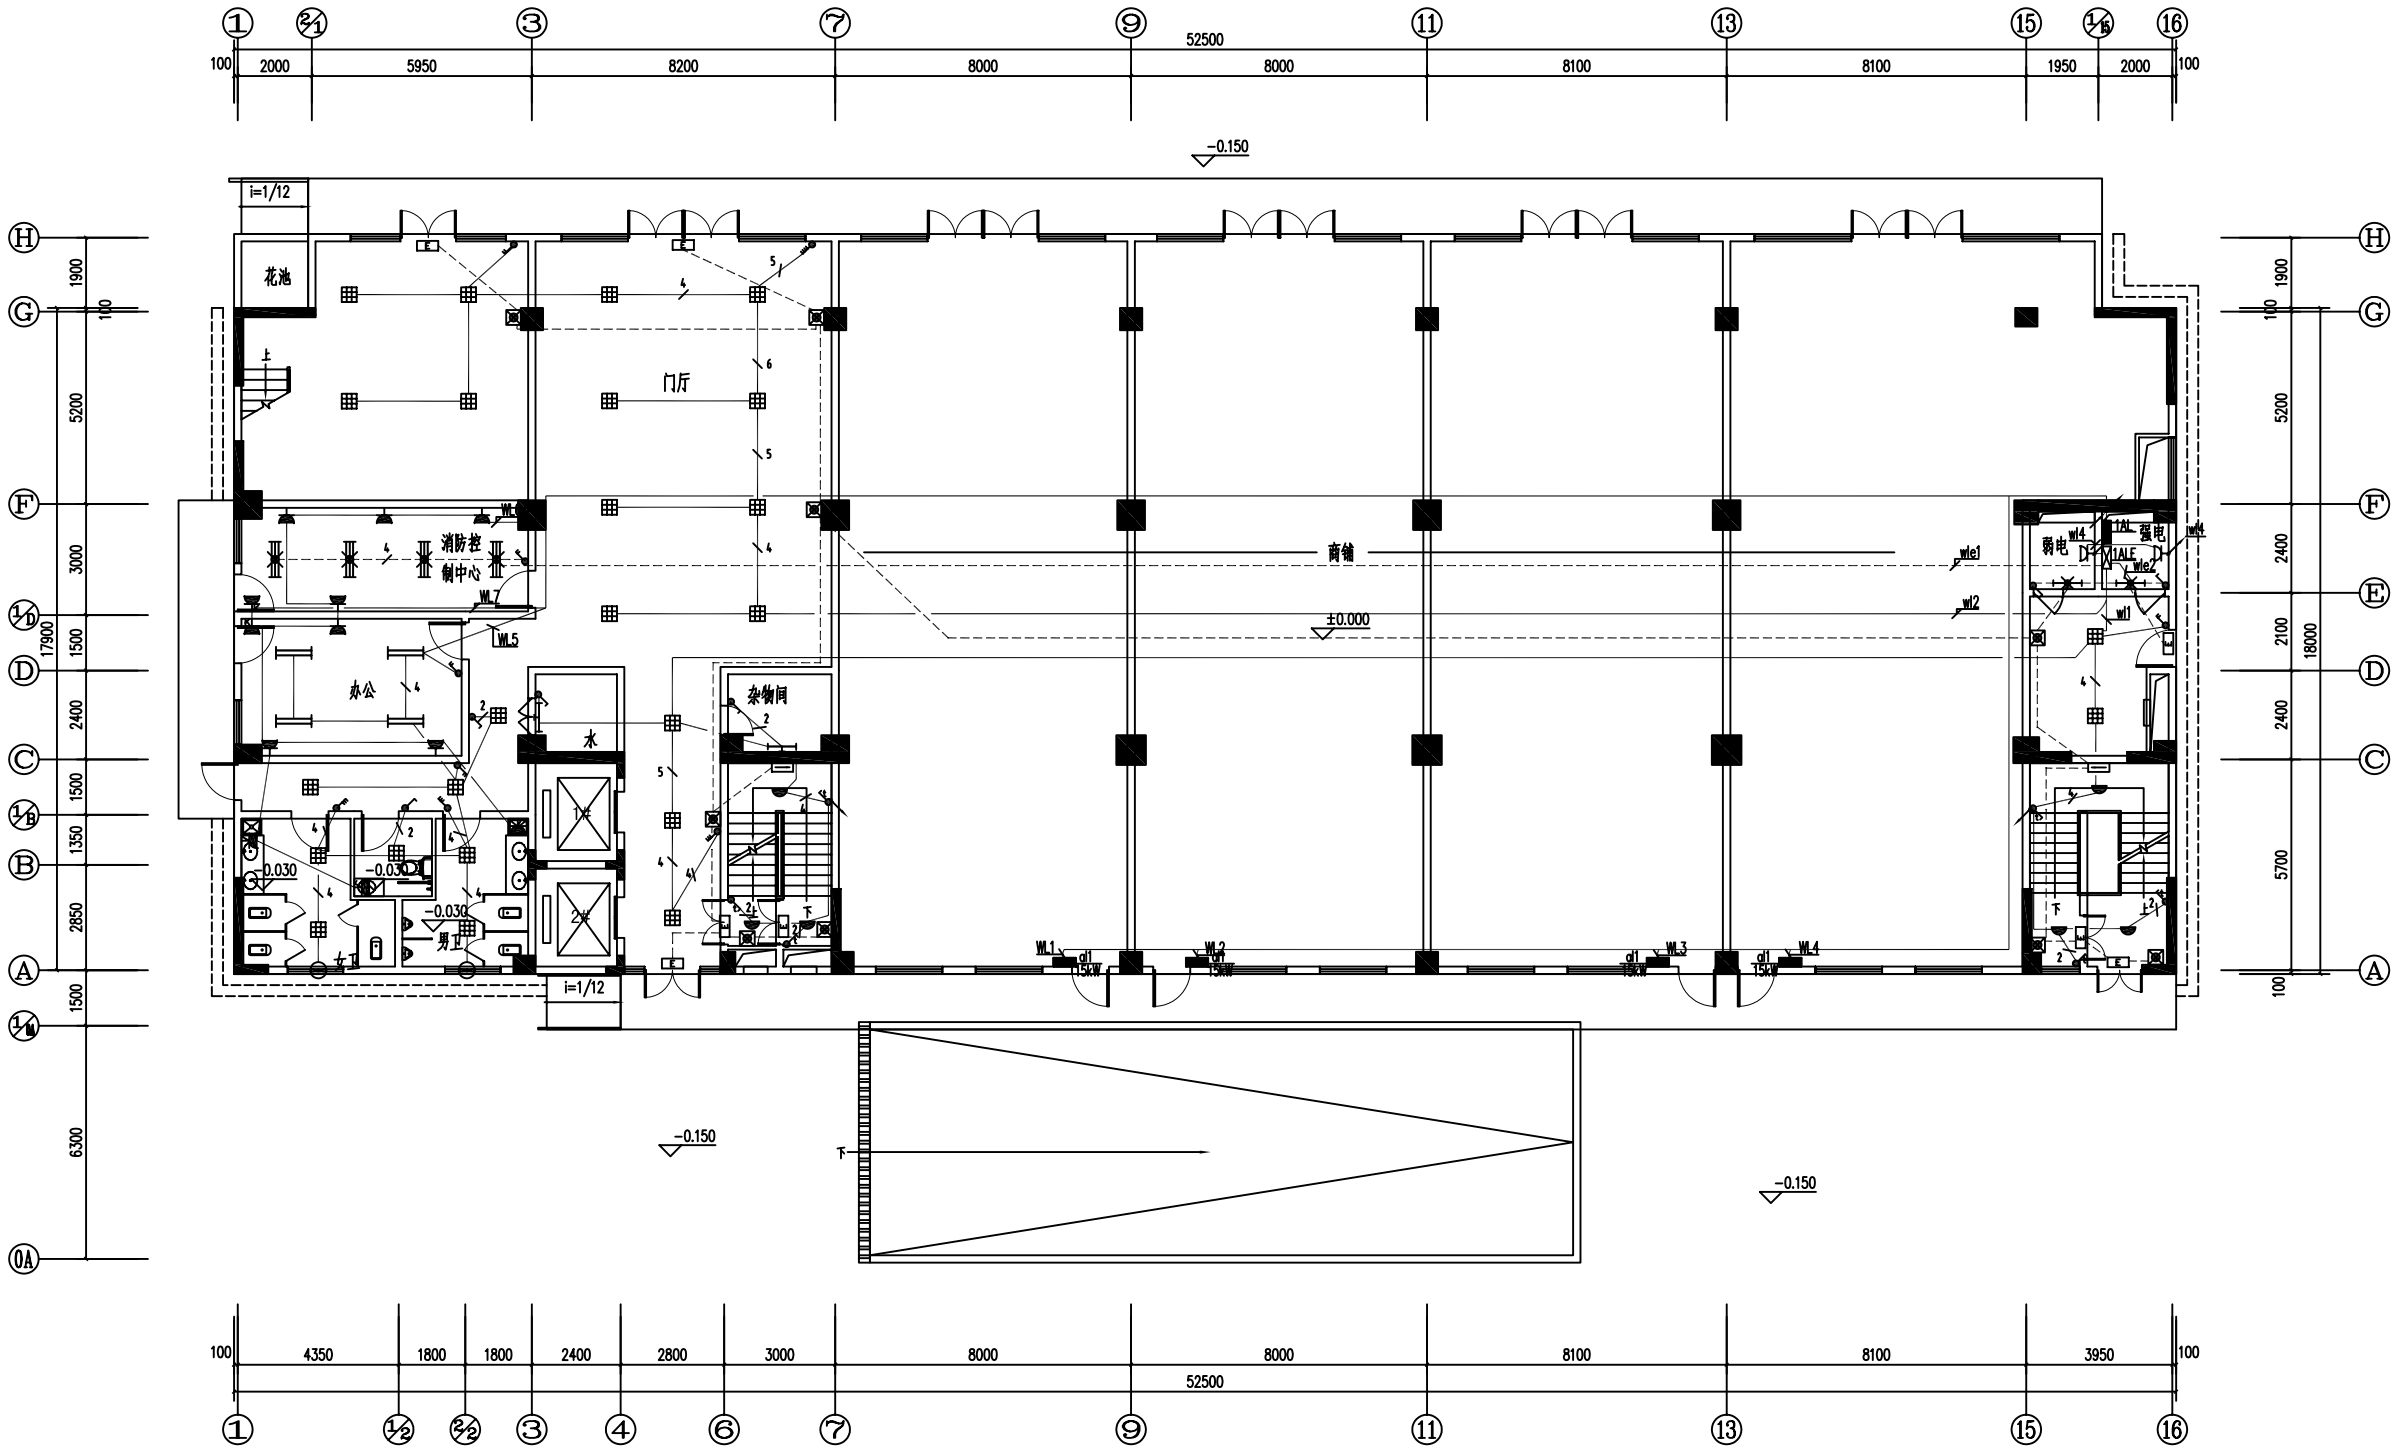

一层照明平面图 1:100

21		排气扇	250V, 48W	窗上	
20		格栅荧光灯 (T8三基色节能荧光灯, 配电子镇流器)	3x18W	吸顶	
19		荧光灯 (T8三基色节能荧光灯, 配电子镇流器)	1x18W	壁装	2.5
18		格栅灯 (带格栅罩) (T8三基色节能荧光灯, 配电子镇流器)	1x18W	壁装	2.5
17		格栅灯 (带格栅罩) (T5三基色节能荧光灯, 配电子镇流器)	3x28W	管吊式	2.8
16		荧光灯 (T5三基色节能荧光灯, 配电子镇流器)	2x28W	管吊式	2.8
15		疏散指示灯 (单面)	1x3W	壁装	0.3
14		安全出口指示	1x3W	门头安装	
13		应急照明灯 (带锂电池)	2x8W(自容灯)	壁装	2.5
12		声光控延时开关 (A型)	PAK-V8E15.WWW	暗装	1.3
11		跷板开关	250V, 10A	暗装	1.3
10		跷板开关	250V, 10A	暗装	1.3
9		跷板开关	250V, 10A	暗装	1.3
8		跷板开关	250V, 10A	暗装	1.3
7		洗手台插座 (二、三孔, 防溅, 保护门)	250V, 10A	暗装	1.5
6		空调插座 (三孔, 带开关)	250V, 10A	暗装	2.0
5		插座 (二、三孔, 带保护门)	250V, 10A	暗装	1.3
4		插座 (二、三孔, 带保护门)	250V, 10A	暗装	0.3
3		吸顶灯 (T5环型节能荧光灯, 配电子镇流器, 带格栅罩)	250V, 32W	吸顶	
2		应急照明配电箱	XXF	明装	1.5
1		照明配电箱	XXM	明装	1.5
序号	图例	名称	规格	安装方式	安装高度(m)

审图专用章			
出图专用章			
执业注册章			
建设 单位			
工程 名称			
子 项 名称			
综合楼(一)			
图 名			
一层照明平面图			
项目负责		马福兴	
专业负责		罗峰	
设 计		罗峰	
制 图		罗峰	
校 对		谢德军	
审 核		廖原	
审 定		廖原	
设计号		11117	专业
日期		2011.11	图号
设计阶段		施工图	12
		版号	1